

LEGEND:

B - BUILDING / F - FACILITY / HWS - HAND WASHING STATION /
OWT - OVERHEAD WATER TANK / CC - CONCRETE CISTERN /
TB - TRANSFORMER BANKING / G - GENERATOR


CAMPUS - A: (EXISTING) BUILDINGS / FACILITIES

B31	ADMINISTRATION BUILDING
B32	MULTI-FACILITY SERVICES OFFICE BUILDING
B33	UNIVERSITY REGISTRAR BUILDING
B34	FACULTY LOUNGE / CANTEN BUILDING
B35	TECHNOPRESENTATION DEVELOPMENT CENTER BUILDING
B36	BUILDING COMPONENT OF SMART CAMPUS BUILDING
B37	MOTORPOOL / PHYSICAL PLANT & ENGINEERING SERVICES
B38	SECURITY OFFICE BUILDING
B39	UNIVERSITY LIBRARY BUILDING
B40	UNIVERSITY MUSEUM / CSSTP BUILDING
B41	STORAGE BUILDING FOR DIFFERENT OFFICES BUILDING
B42	EXECUTIVE BUILDING
B43A	COLLEGE OF LIBERAL ARTS - BUILDING A
B43B	COLLEGE OF LIBERAL ARTS - BUILDING B
B44	RESEARCH CENTER BUILDING
B45	COLLEGE OF LAW BUILDING
B46	CLAW - CANTEN
B47	COLLEGE OF PUBLIC ADMINISTRATION BUILDING
B48	CLA - GRADUATE PROGRAM BUILDING
F01	CARPENTRY SHOP
F02	OPEN STORAGE FACILITIES
F03	EXECUTIVE COVERED PARKING
F04	GUARD OUTPOST @ GATE-01
F05	SATERO
F06	PARKING AREA-1 (existing) UNIV. LIBRARY, EXECUTIVE, CLAW, GRADS
F07	GRADS - STUDENT KIOSK
HWS-1	HAND WASHING STATION @ SECURITY OFFICE BUILDING
HWS-2	HAND WASHING STATION @ GRADS
B49	OSA / STUDENT CENTER BUILDING
B50	UNIVERSITY HEALTH CENTER BUILDING
B51	CITE - SPEED BUILDING
B52	CSE - STUDENT CHAPTER ORGANIZATION OFFICE BUILDING
B53	ENGINEERING INNOVATION CENTER BUILDING
B54	CSE - ECE CLASSROOMS
B55	COLLEGE OF ENGINEERING BLDG. (NEW)
B56	CSE - ME LABORATORY ROOM
B57	CSE - GLASS ROOMS
B58	COLLEGE OF ENGINEERING BLDG. (OLD)
B59	STUDENT COMPUTER CENTER / ADMISSION BUILDING
B60A	LS - ELEMENTARY ADMIN. BUILDING
B60B	LS - ELEMENTARY MULTIPURPOSE BUILDING
B60C	COLLEGE OF ARCHITECTURE - CSE OFFICE
B61	COLLEGE OF ARCHITECTURE BUILDING
B62	WATER REILLING STATION BUILDING
B63	LS - ELEMENTARY STUDENT CENTER
B64	(VACANT SPACE)
B65	LS - ELEMENTARY BUILDING (OLD)
B66	LS - ELEMENTARY BUILDING (NEW)
B67	WASU - COOPERATIVE BUILDING
B68	RENTABLE SPACE (LOCKER/STORAGE/STUDENT CENTER)
B69	BUILDING UTILISE BY LANDBANK
B70	EXTENSION TRAINING LABORATORY (RESEARCH BUILDING)
B71A	BS HOTEL & RESTAURANT MANAGEMENT - BUILDING
B72	CSE & DETARY BUILDING
B73	UNIVERSITY HOTEL BUILDING
F09	CSE - OPEN STAGE
F10	CSE (NEW) - STUDENT KIOSK
F11	CSE (OLD) - STUDENT KIOSK
F12	LS - ELEMENTARY WAITING SHED
F13	COVERED COURT
F14	MOBILE CANTEN
F15	GUARD OUTPOST @ GATE 4
HWS-3	HAND WASHING STATION @ LS - ELEMENTARY BUILDING
HWS-4	HAND WASHING STATION @ GATE 4
OWT-1	OVERHEAD WATER TANK @ COLLEGE OF ENG. BLDG. (OLD)
B74	RENTABLE SPACE (COMMERCIAL)
B75	ALUMNI BUILDING
B76	COLLEGE OF NURSING STUDENT CENTER
B77	COLLEGE OF NURSING BUILDING
B78	COLLEGE OF NURSING BUILDING (ANNEX BUILDING)
B79	UNIVERSITY PRESS
B80	UNIVERSITY CANTEN
B81	COLLEGE OF TEACHERS EDUCATION BUILDING
B82	UNIVERSITY MUSEUM (AZOTEA)
F16	GUARD OUTPOST @ GATE 3
F17	UNIVERSITY COURTYARD
F18	PARKING AREA-1 (existing) UNIV. STUDENT CENTER, UNIV. CLINIC
F19	UNIVERSITY OPEN STAGE
F20	OPEN COURT
F21	PEDESTRIAN OVERPASS (FROM CAMPUS A TO B)
HWS-5	HAND WASHING STATION @ UNIVERSITY PRESS BUILDING
HWS-6	HAND WASHING STATION @ GATE 3


CAMPUS - B: (EXISTING) BUILDINGS / FACILITIES

B01	COLLEGE OF SCIENCE AND MATHEMATICS BUILDING
B02	NATURAL SCIENCE BUILDING (CSM)
B03	LS-HIGH SCHOOL BUILDING
B04	COLLEGE OF MEDICINE BUILDING
B05	DEFED - SATELLITE OFFICE BUILDING (FORMER)
B06	TRAINING CENTER BUILDING
B07	LADIES DORMITORY/FOOD SERVICE CENTER
B08	AL-FRESKO
B09	COLLEGE OF CRIMINAL JUSTICE EDUCATION BUILDING
B10	CSM - MATHEMATICS & STATISTICS DEPARTMENT
B11	COLLEGE OF ASIAN AND ISLAMIC STUDIES BUILDING
B12	COLLEGE OF SOCIAL WELFARE & DEVELOPMENT BUILDING
B13	STUDENT KIOSK (CSMO)
B14	DORMITORY BUILDING
B15	SCIENCE & TECHNOLOGY HUB / CCS BUILDING
B16	MUSLIM STUDENT AFFAIR BUILDING
B17	MEDICAL HEALTH CENTER
B18A	COLLEGE OF MEDICINE BUILDING-A (ANNEX BUILDING)
B18B	COLLEGE OF MEDICINE BUILDING-B (B18C)
B19	TESTING EVALUATION CENTER (P.S. PRACTICAL ARTS BLDG.)
B20	(VACANT SPACE)
F01	CSM - STUDENT KIOSK
F02	CSM - FACULTY CANTEN
F03	CSM - COLLEGE STUDENT COUNCIL OFFICE
F04	GUARD OUTPOST @ GATE 6
F05	PUMPING STATION @ LS - HIGH SCHOOL BUILDING
F06	MALE AND FEMALE COMFORT ROOM @ CSM BUILDING
F07	PARKING AREA-2 (existing) CSE, CAG, SCIENCE HUB BUILDING
F08	CANTEN (CONTAINER VAN)
F09	GARDENLANDSCAPE @ MEDICAL HEALTH CENTER
F10	GUARD OUTPOST @ GATE 9
HWS-1	HAND WASHING STATION @ AL-FRESKO
HWS-2	HAND WASHING STATION @ GATE 9
OWT-1	OVERHEAD WATER TANK @ CSM BUILDING
OWT-2	OVERHEAD WATER TANK @ FOOD SERVICE CENTER BLDG.
OWT-3	OVERHEAD WATER TANK @ COL. OF MED. BLDG. B (B18C)
TRANSFORMER BANKING	
TB-1	TRANSFORMER BANKING @ CARPENTRY SHOP
TB-2	TRANSFORMER BANKING @ CARPENTRY SHOP
TB-3	TRANSFORMER BANKING @ CLEM. PRINCIPAL OFFICE
TB-4	TRANSFORMER BANKING @ CSM - GATE 6
TB-5	TRANSFORMER BANKING @ COLLEGE OF MEDICINE - GATE 3
GENERATOR SET	
G-1	GENERATOR SET - CARPENTRY SHOP
G-2	GENERATOR SET - RESEARCH CENTER BUILDING
G-3	GENERATOR SET - ENGINEERING INNOVATION CENTER
G-4	GENERATOR SET - ELEMENTARY LS BUILDING (OLD)
G-5	GENERATOR SET - ALUMNI BUILDING
G-6	GENERATOR SET - CSM
G-7	GENERATOR SET - SCIENCE & TECHNOLOGY HUB
G-8	GENERATOR SET - HIGH SCHOOL LS BUILDING (NEW)
G-9	GENERATOR SET - RSTC
G-10	GENERATOR SET - CARPENTRY SHOP (PROPOSED)
OTHER FACILITIES	
CC-1	CONCRETE CISTERN @ CSM BUILDING
CC-2	CONCRETE CISTERN @ LS - HIGH SCHOOL BUILDING
CC-3	CONCRETE CISTERN @ LS - PRACTICAL ARTS BLDG.
CC-4	CONCRETE CISTERN @ SCIENCE & TECHNOLOGY HUB BLDG.

B - BUILDING
F - FACILITY
HWS - HAND WASHING STATION
OWT - OVERHEAD WATER TANK
CC - CONCRETE CISTERN
TB - TRANSFORMER BANKING
G - GENERATOR

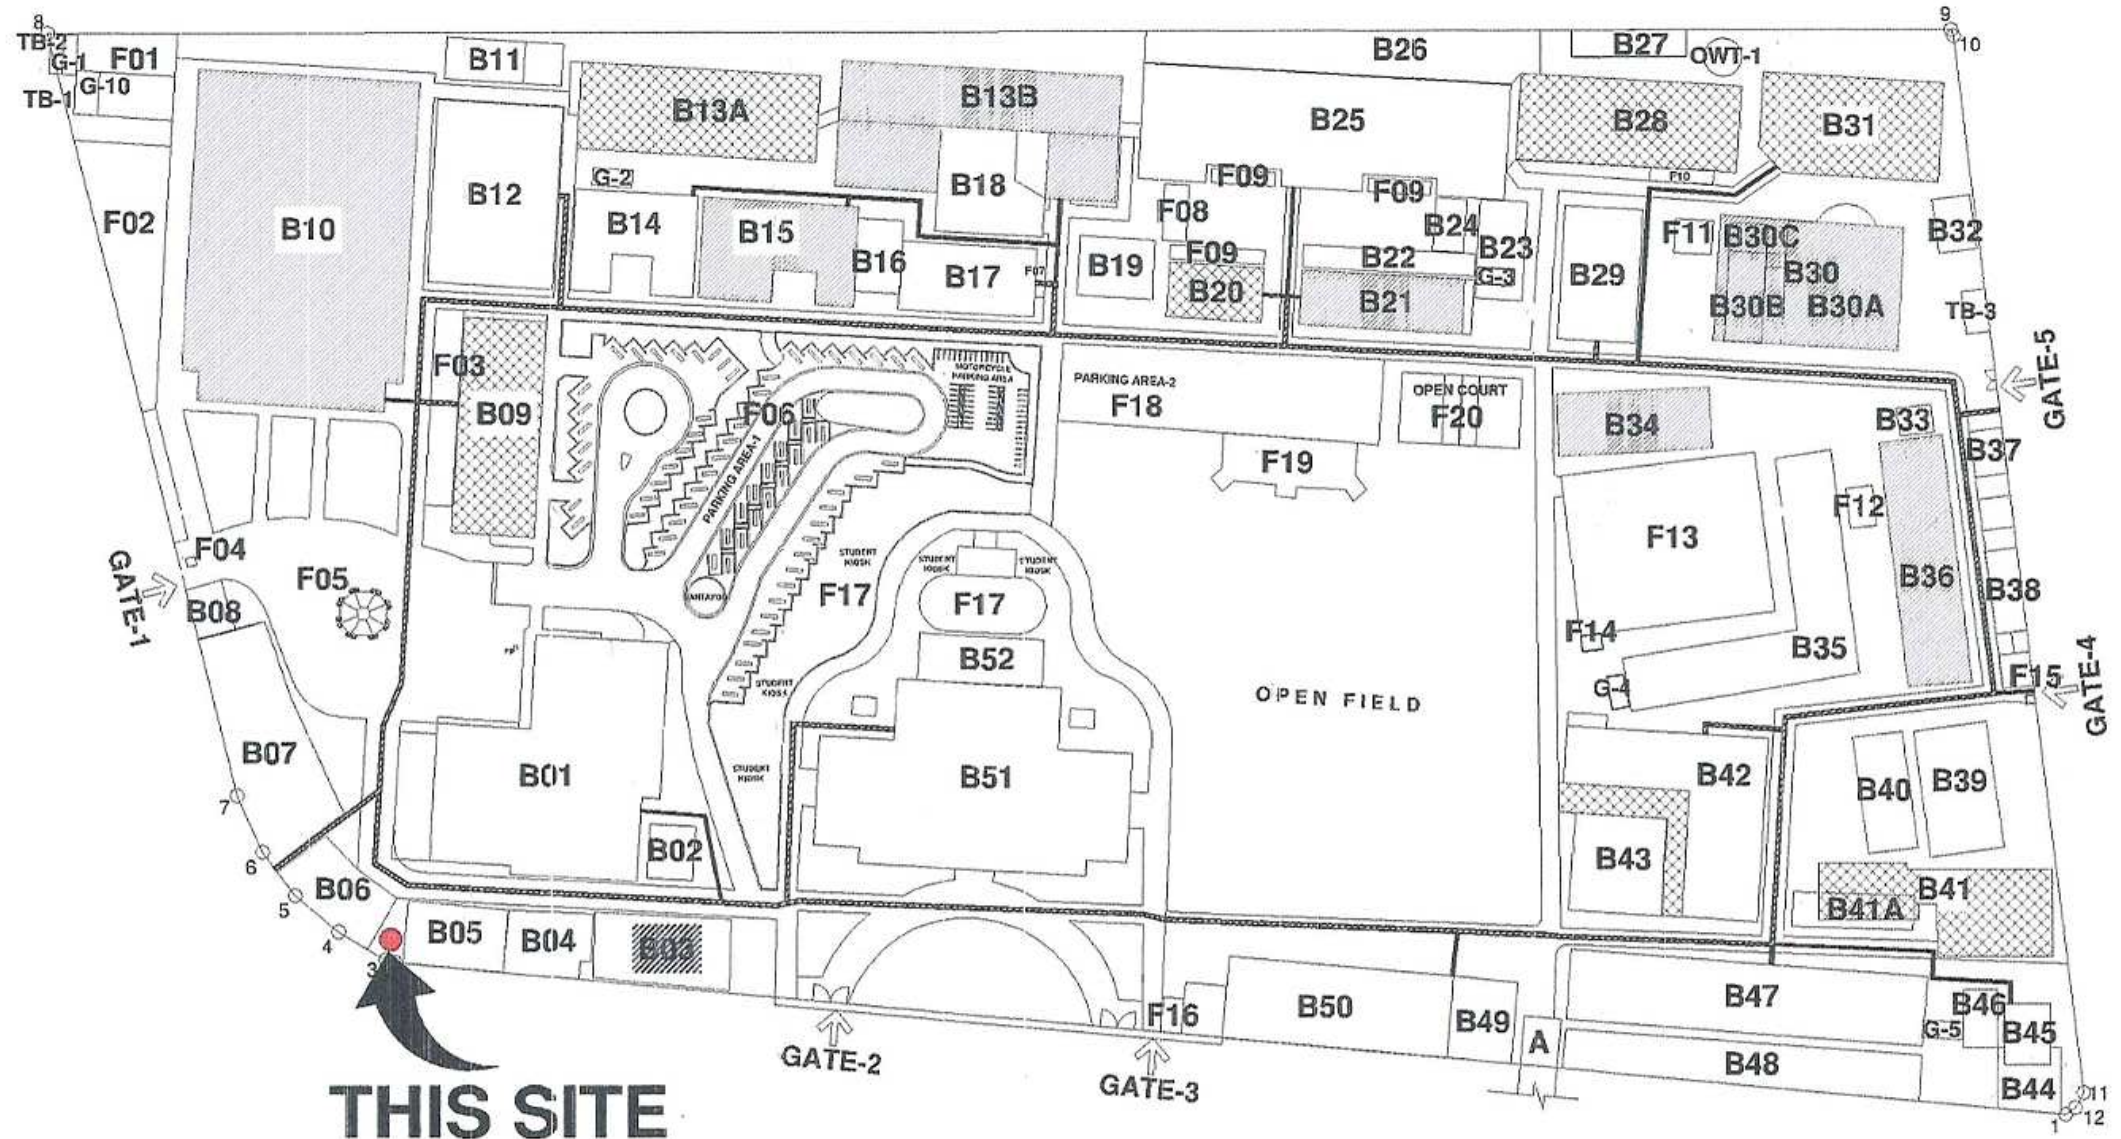

THIS SITE
PROPOSED 1
UNIT-165KVA GENSET

 

CAMPUS - A EXCAVATION PLAN

SCALE 1:850



DESIGNED BY:
ENGR. RICARDO B. GONZALES
UNIVERSITY ELECTRICAL ENGINEER
PRC: 23724
TIN: 275-203-178

PROJECT TITLE:
**ADAPTION OF DIGITAL LEARNING
PLATFORM THROUGH ICT MODERNIZATION**
LOCATION: NORMAL ROAD, BALIWASAN, ZAMBOANGA CITY, 7000

REQUISITIONER
ENGR. FERDINAND S. GUARDO

RECOMMENDING APPROVAL
ARCH. JOSEPH ANDREW L. SAHIAL, UAP
DIRECTOR OF PHYSICAL PLANT
AND ENGINEERING SERVICES
PRC: 6010577
PTR: 2829281
TIN: 445-013-228

RECOMMENDING APPROVAL
DR. JOSELYN D. MADRONAL
VICE PRESIDENT FOR ADMIN AND
FINANCE

APPROVED BY:
DR. MA. CARLA A. OCHOTORENA
WMSU-PRESIDENT

SHEET CONTENTS
AS SHOWN
PREPARED BY:
ENG. KENT

SHEET NO.
A01
0000

WMSU-PPES-
FR-XXX-XX
EFFECTIVE DATE:
XX XXXX XXXX



LEGEND:

B - BUILDING / F - FACILITY / HWS - HAND WASHING STATION /
OWT - OVERHEAD WATER TANK / CC - CONCRETE CISTERN /
TB - TRANSFORMER BANKING / G - GENERATOR



CAMPUS - A: (EXISTING) BUILDINGS / FACILITIES

CAMPUS - B: (EXISTING) BUILDINGS / FACILITIES

B01	ADMINISTRATION BUILDING
B02	MULTI-FATH SERVICES OFFICE BUILDING
B03	UNIVERSITY REGISTRAR BUILDING
B04	FACULTY LOUNGE / CANTEN BUILDING
B05	TECHNOLOGY SHIP DEVELOPMENT CENTER BUILDING
B06	BUILDING COMPONENT OF SMART CAMPUS BUILDING
B07	MOTORPOOL / PHYSICAL PLANT & ENGINEERING SERVICES
B08	SECURITY OFFICE BUILDING
B09	UNIVERSITY LIBRARY BUILDING
B10	UNIVERSITY GYMNASIUM / CSPE BUILDING
B11	STORAGE BUILDING FOR DIFFERENT OFFICES BUILDING
B12	EXECUTIVE BUILDING
B13A	COLLEGE OF LIBERAL ARTS - BUILDING A
B13B	COLLEGE OF LIBERAL ARTS - BUILDING B
B14	RESEARCH CENTER BUILDING
B15	COLLEGE OF LAW BUILDING
B16	CLAW - CANTEN
B17	COLLEGE OF PUBLIC ADMINISTRATION BUILDING
B18	CLA - GRADUATE PROGRAM BUILDING
F01	CARPENTRY SHOP
F02	OPEN STORAGE FACILITIES
F03	EXECUTIVE COVERED PARKING
F04	GUARD OUTPOST @ GATE-01
F05	GAZEBO
F06	PARKING AREA-1 (existing) UNIV. LIBRARY, EXECUTIVE, CLAW, CPADS
F07	CPADS - STUDENT KIOSK
HWS-1	HAND WASHING STATION @ SECURITY OFFICE BUILDING
HWS-2	HAND WASHING STATION @ CPADS
B19	OSA / STUDENT CENTER BUILDING
B20	UNIVERSITY HEALTH CENTER BUILDING
B21	CIE - SPED BUILDING
B22	CIE - STUDENT CHAPTER ORGANIZATION OFFICE 1 BUILDING
B23	ENGINEERING INNOVATION CENTER BUILDING
B24	CIE - RISE CLASSROOMS
B25	COLLEGE OF ENGINEERING BLDG. (HILM)
B26	CIE - ME LABORATORY ROOM
B27	CIE - CLASSROOMS
B28	COLLEGE OF ENGINEERING BLDG. (OLD)
B29	STUDENT COMPUTER CENTER / ADMISSION BUILDING
B30A	ILS - ELEMENTARY ADMIN. BUILDING
B30B	ILS - ELEMENTARY MULTIPURPOSE BUILDING
B31	COLLEGE OF ARCHITECTURE - CSE OFFICE
B32	COLLEGE OF ARCHITECTURE BUILDING
B33	WATER TREATMENT STATION BUILDING
B34	ILS - ELEMENTARY STUDENT CENTER
B35	(VACANT SPACE)
B36	ILS - ELEMENTARY BUILDING (OLD)
B37	ILS - ELEMENTARY BUILDING (NEW)
B38	WMSU - COOPERATIVE BUILDING
B39	RENTABLE SPACE (DOH-ZONE: QUACAS-CENTER)
B40	BUILDING UTILISE BY LANDMARK
B41A	EXTENSION TRAINING LABORATORY (MEDIA BUILDING)
B41B	BS-HOTEL & RESTAURANT MANAGEMENT - BUILDING
B42	CIE & DETARY BUILDING
B43	UNIVERSITY HOTEL BUILDING
F08	CIE - OPEN STAGE
F09	CIE (NEW) - STUDENT KIOSK
F10	CIE (OLD) - STUDENT KIOSK
F11	GUARICH - STUDENT KIOSK
F12	ILS - ELEMENTARY WATERFURNISHED
F13	COVERED COURT
F14	MOBILE CANTEN
F15	GUARD OUTPOST @ GATE 4
HWS-3	HAND WASHING STATION @ ILS - ELEMENTARY BUILDING
HWS-4	HAND WASHING STATION @ GATE 4
OWT-1	OVERHEAD WATER TANK @ COLLEGE OF ENG'G. BLDG. (OLD)
B44	RENTABLE SPACE (COMMERCIAL)
B45	ALUMNI BUILDING
B46	COLLEGE OF NURSING STUDENT CENTER
B47	COLLEGE OF NURSING BUILDING
B48	COLLEGE OF NURSING BUILDING (ANNEX BUILDING)
B49	UNIVERSITY PRESS
B50	UNIVERSITY CANTEN
B51	COLLEGE OF TEACHERS EDUCATION BUILDING
B52	UNIVERSITY MUSEUM (AZOTEM)
F16	GUARD OUTPOST @ GATE 3
F17	UNIVERSITY COURTYARD
F18	PARKING AREA-1 (existing) UNIV. STUDENT CENTER, UNIV. CLINIC
F19	UNIVERSITY OPEN STAGE
F20	OPEN COURT
F21	PEDESTRIAN OVERPASS (FROM CAMPUS A TO B)
HWS-5	HAND WASHING STATION @ UNIVERSITY PRESS BUILDING
HWS-6	HAND WASHING STATION @ GATE 3

B01	COLLEGE OF SCIENCE AND MATHEMATICS BUILDING
B02	MATERIAL SCIENCE BUILDING (CSM)
B03	ILS-HIGH SCHOOL BUILDING
B04	COLLEGE OF MEDICINE BUILDING
B05	DEPED - SATELLITE OFFICE BUILDING (FORMER)
B06	TRAINING CENTER BUILDING
B07	LADIES DORMITORY/FOOD SERVICE CENTER
B08	AL-FRESQO
B09	COLLEGE OF CHEMICAL JUSTICE EDUCATION BUILDING
B10	CSM - MATHEMATICS & STATISTICS DEPARTMENT
B11	COLLEGE OF ASIAN AND ISLAMIC STUDIES BUILDING
B12	COLLEGE OF SOCIAL WELFARE & DEVELOPMENT BUILDING
B13	STUDENT KIOSK (CSWD)
B14	DORMITORY BUILDING
B15	SCIENCE & TECHNOLOGY HUB / CDS BUILDING
B16	MUSEUM STUDENT AFFAIR BUILDING
B17	MEDICAL HEALTH CENTER
B18A	COLLEGE OF MEDICINE BUILDING-A (ANNEX BUILDING)
B18B	COLLEGE OF MEDICINE BUILDING-B (RSTC)
B19	TESTING (EVALUATION CENTER (ILS, PRACTICAL, ARTS BLDG.))
B20	(VACANT SPACE)
F01	CSM - STUDENT KIOSK
F02	CSM - FACULTY CANTEN
F03	CSM - COLLEGE STUDENT COUNCIL OFFICE
F04	GUARD OUTPOST @ GATE 5
F05	PUMPING STATION @ ILS - HIGH SCHOOL BUILDING
F06	MALE AND FEMALE COMFORT ROOM @ CSM BUILDING
F07	PARKING AREA-2 (existing) COL. CARS, SCIENCE HUB BUILDING
F08	CANTEN (CONTAINER VAN)
F09	GARDEN LANDSCAPE @ MEDICAL HEALTH CENTER
F10	GUARD OUTPOST @ GATE 9
HWS-1	HAND WASHING STATION @ AL-FRESQO
HWS-2	HAND WASHING STATION @ GATE 9
OWT-1	OVERHEAD WATER TANK @ CSM BUILDING
OWT-2	OVERHEAD WATER TANK @ FOOD SERVICE CENTER BLDG.
OWT-3	OVERHEAD WATER TANK @ COL. OF MED. BLDG. B (RSTC)
TRANSFORMER BANKING	
TB-1	TRANSFORMER BANKING @ CARPENTRY SHOP
TB-2	TRANSFORMER BANKING @ CARPENTRY SHOP
TB-3	TRANSFORMER BANKING @ ILSM, PRINCIPAL OFFICE
TB-4	TRANSFORMER BANKING @ CSM - GATE 8
TB-5	TRANSFORMER BANKING @ COLLEGE OF MEDICINE - GATE 9
GENERATOR SET	
G-1	GENERATOR SET - CARPENTRY SHOP
G-2	GENERATOR SET - RESEARCH CENTER BUILDING
G-3	GENERATOR SET - ENGINEERING INNOVATION CENTER
G-4	GENERATOR SET - ELEMENTARY ILS BUILDING (OLD)
G-5	GENERATOR SET - ALUMNI BUILDING
G-6	GENERATOR SET - CSM
G-7	GENERATOR SET - SCIENCE & TECHNOLOGY HUB
G-8	GENERATOR SET - HIGH-SCHOOL ILS BUILDING (NEW)
G-9	GENERATOR SET - RSTC
G-10	GENERATOR SET - CARPENTRY SHOP (PROPOSED)
OTHER FACILITIES	
CC-1	CONCRETE CISTERN @ CSM BUILDING
CC-2	CONCRETE CISTERN @ ILS - HIGH SCHOOL BUILDING
CC-3	CONCRETE CISTERN @ ILS, PRACTICAL ARTS BLDG.
CC-4	CONCRETE CISTERN @ SCIENCE & TECHNOLOGY HUB BLDG.

B - BUILDING
F - FACILITY
HWS - HAND WASHING STATION
OWT - OVERHEAD WATER TANK
CC - CONCRETE CISTERN
TB - TRANSFORMER BANKING
G - GENERATOR

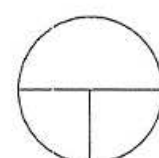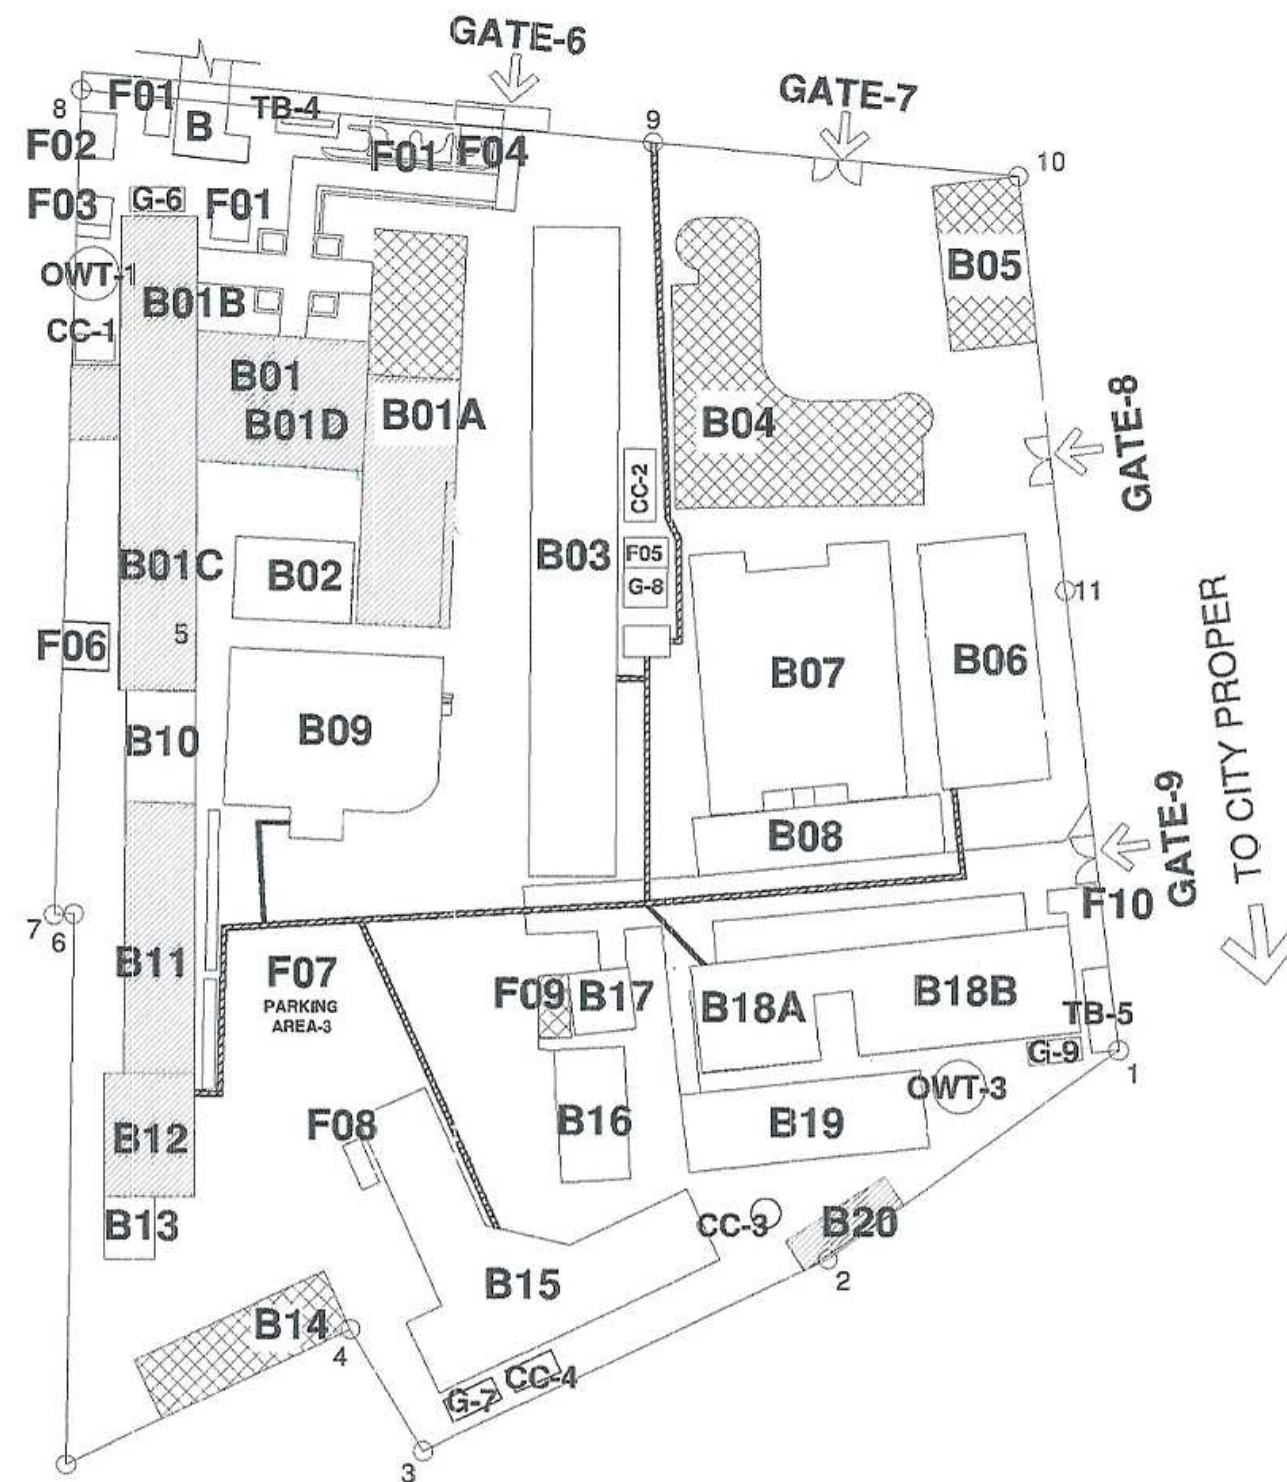

CAMPUS - B EXCAVATION PLAN

SCALE 1:850



DESIGNED BY:
ENGR. RICARDO B. GONZALES
UNIVERSITY ELECTRICAL ENGINEER
PRC: 23724
TIN: 275-203-179

PROJECT TITLE:
**ADAPTION OF DIGITAL LEARNING
PLATFORM THROUGH ICT MODERNIZATION**
LOCATION: NORMAL ROAD, BALIWASAN, ZAMBANGA CITY, 7003

REQUISITIONER
ENGR. FERDINAND S. GUARDO

RECOMMENDING APPROVAL
ARCH. JOSEPH ANDREW L. SAHIAL, UAP
DIRECTOR OF PHYSICAL PLANT
AND ENGINEERING SERVICES
PRC: 0010577
PTR: 2929291
TIN: 445-013-228

RECOMMENDING APPROVAL
DR. JOSELITO D. MADROÑAL
VICE PRESIDENT FOR ADMIN AND
FINANCE


APPROVED BY:
DR. MA. CARLA A. OCHOTORENA
WMSU-PRESIDENT

SHEET CONTENTS
AS SHOWN
PREPARED BY:
ENG. KENT

SHEET NO.
A01
00/00

WMSU-PPES-
FR-XXX-XX
EFFECTIVE DATE:
XX XXXX XXXX



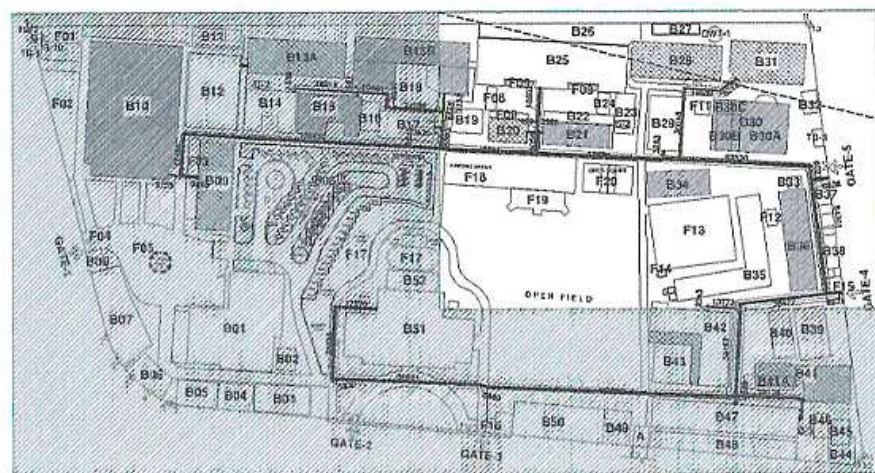

CAMPUS - A ELECTRICAL LAYOUT
SCALE 1:150



GENERAL NOTES

- All works herein shall be done in accordance with the latest edition of the Philippine Electrical Code (PEC). Relatively the same, it should follow rules and regulations of the National Building Code enforced by the building official of City of Zamboanga, and of local electric cooperative the Zamboanga City Electric Cooperative (ZAMCECO).
- Electrical wiring installation shall be done in Rigid polyvinyl chloride conduits (PVC) otherwise stated. Minimum size for all conduits shall be 20mm diameter electrical trade except for XLPE it must be directly buried.
- Service Voltage Service voltage must come from 13,200/7620V, 3Ø power supply and stepped down to 230 V, 3Ø, 4-wire, through 3 - 50kva Single Phase Amorphous Distribution Transformers and 3 - 50kva Single Phase Amorphous Distribution Transformers.
- Service Entrance must be underground
- All wires shall be 3CORE OR 4CORE XLPE coded as follows:

Line A	-Red
Line B	-Yellow
Line C	-Blue
Neutral	-Yellow with green stripes
Equipment Grounding	-Green
- All lamps fixtures shall be LED type including the emergency light and fire exit sign, lamps shall be daylight white. (For University Electrical Engineer's approval)
- All convenience outlet shall be three(3) prong type, to address proper grounding.
- The mounting height of all wiring devices shall be as follows:
 - Light switches 1400mm above finish floor line.
 - Convenience outlets 300mm above finish floor line or as required
 - Floor mounted outlet must be flush with the finish floor line
 - Panel boards shall be installed 1800mm above finish floor line.
- All termination done with XLPE must be done properly
- All Conductors must undergo insulation resistance test prior to testing.
- There shall be adequate and effective equipment grounding. Ground resistance should be no more than 5 ohms. If ground resistance exceeds 5ohms additional ground rods shall be provided.
- Conductors, Main Breaker, Feeders and Circuit Protection to be used shall be of quality type to ensure safety.
- Grounding Electrode Conductor shall not be smaller than 80mm²/ copper(Cu) or 125mm²/ Aluminum(Al).
- No revision in the design shall be done without prior knowledge and approval of the WMSU-Physical Plant and Engineering Services, any revisions done without approval shall cause responsibility of the designer to cease as a whole.
- All electrical installation shall be done under the direct supervision of a valid license and experienced Electrical Engineer (PEE or REE).



	DESIGNED BY:	PROJECT TITLE:	REQUISITIONER:	RECOMMENDING APPROVAL:	RECOMMENDING APPROVAL:	APPROVED BY:	SHEET CONTENTS:	SHEET NO.	WMSU-PPES- FR-XXX-XX	
	ENGR. RICARDO B. GONZALES UNIVERSITY ELECTRICAL ENGINEER	ADAPTION OF DIGITAL LEARNING PLATFORM THROUGH ICT MODERNIZATION	ENGR. FERDINAND S. GUARDO	ARCH. JOSEPH ANDREW L. SAHIA, UAP DIRECTOR OF PHYSICAL PLANT AND ENGINEERING SERVICES	DR. JOSELITO D. MADRONAL VICE PRESIDENT FOR ADMIN AND FINANCE	DR. MA. CARLA P. OCHOTORENA WMSU PRESIDENT	AS SHOWN		EFFECTIVE DATE: XX XXXX XXXX	
	PRC: 23724	TIN: 275-203-179	LOCATION: NORMAL ROAD, BALIWASAN, ZAMBOANGA CITY, 7000	PRC: 0010577	PTR: 2929291	TIN: 445-013-228	PREPARED BY: ENG. KENT			

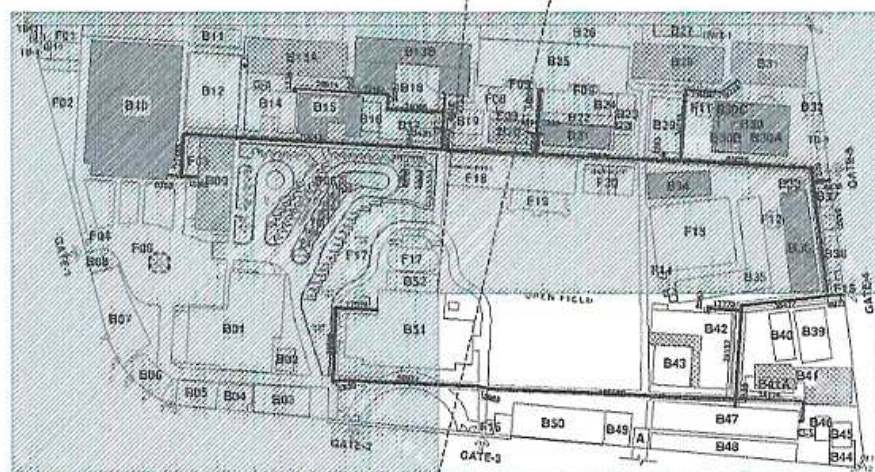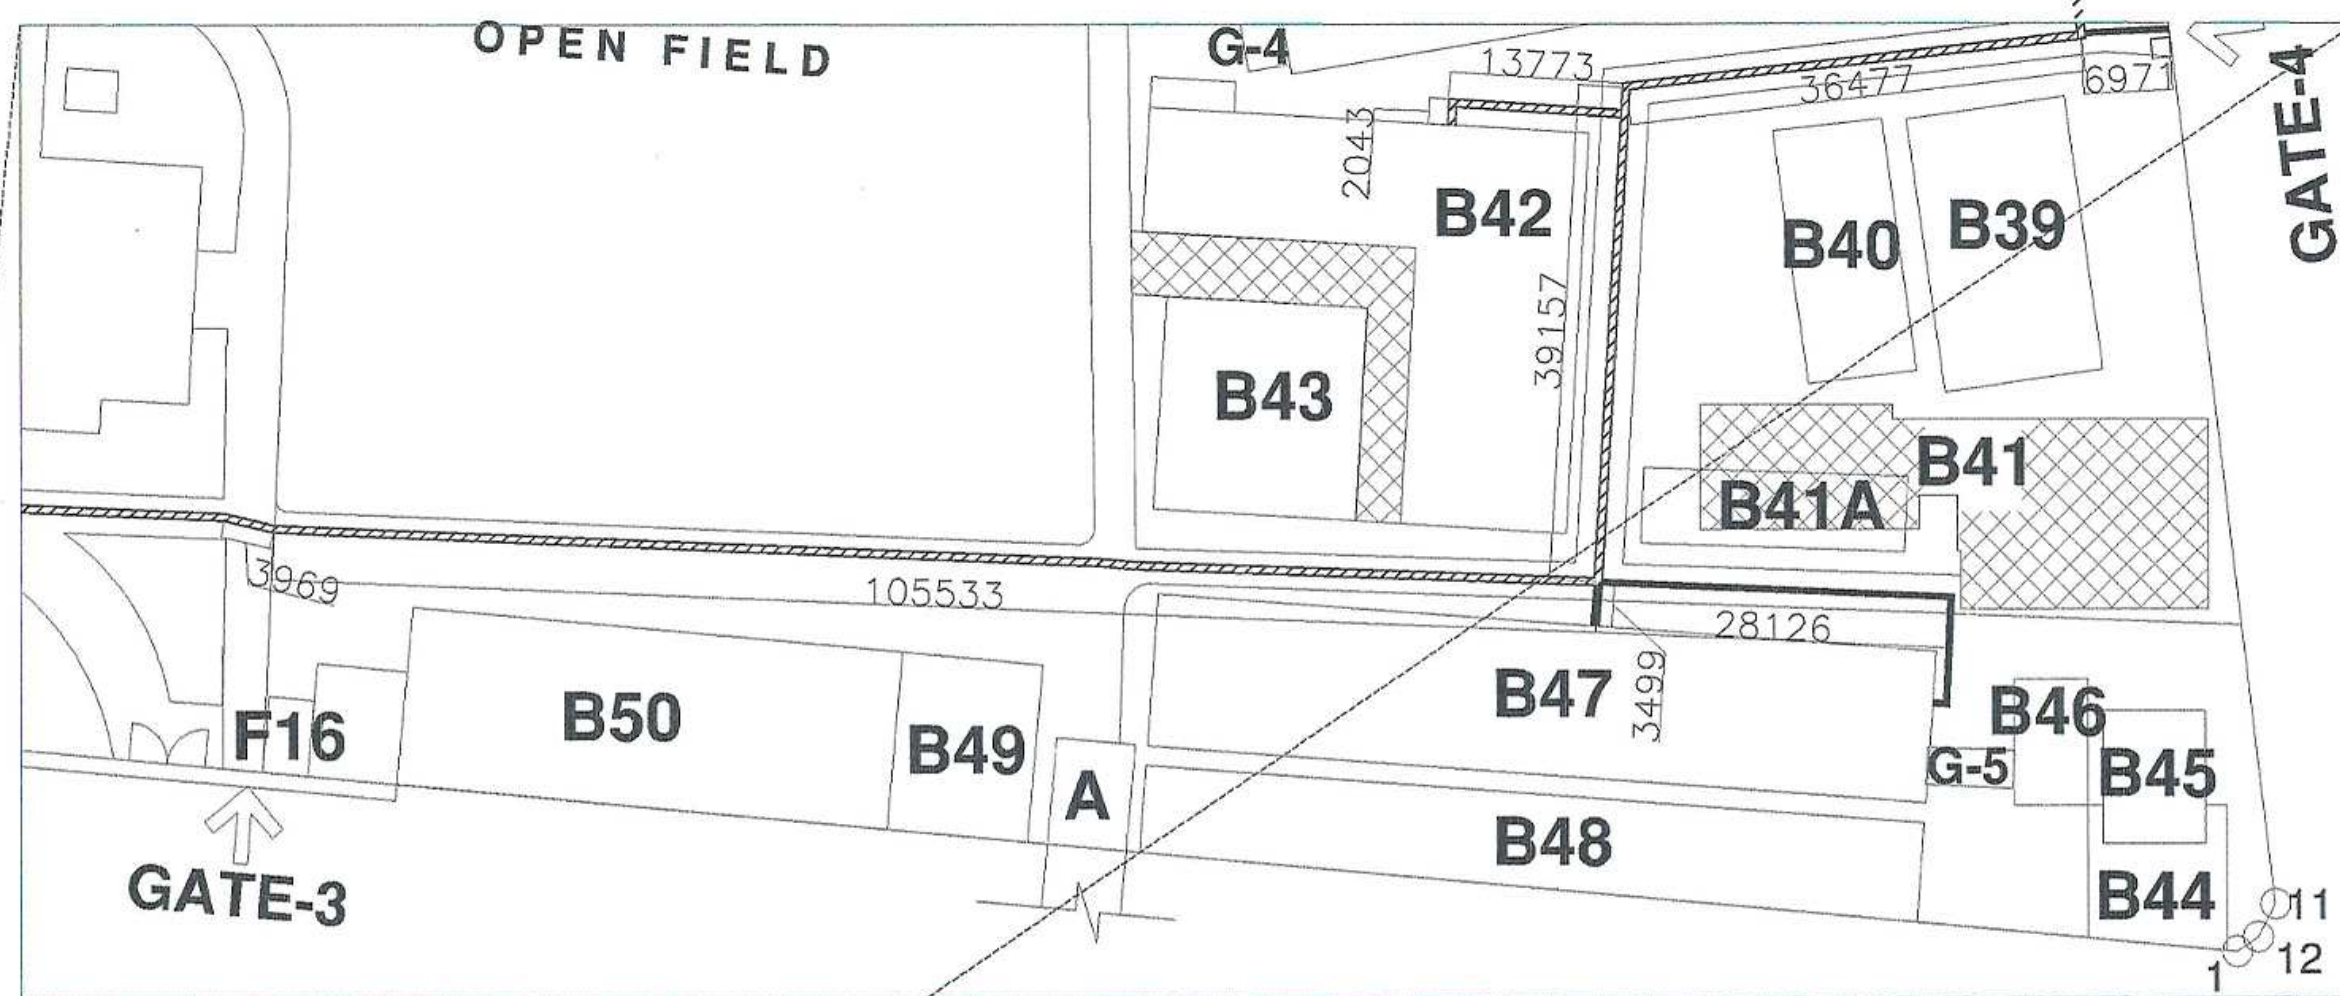

CAMPUS - A ELECTRICAL LAYOUT
SCALE 1:1000



DESIGNED BY:
ENGR. RICARDO B. GONZALES
UNIVERSITY ELECTRICAL ENGINEER
PRC: 23724 TIN: 275-203-173

PROJECT TITLE:
**ADAPTION OF DIGITAL LEARNING
PLATFORM THROUGH ICT MODERNIZATION**
LOCATION: NORMAL ROAD, BALIWASAN, ZAMBOANGA CITY, 7600

REQUISITIONER:
ENGR. FERDINAND S. GUARDO

RECOMMENDING APPROVAL:
ARCH. JOSEPH ANDREW L. SAHIAL, UAP
DIRECTOR OF PHYSICAL PLANT
AND ENGINEERING SERVICES
PRC: 0010577 PTR: 2929291 TIN: 445-013-228

RECOMMENDING APPROVAL:
DR. JOSELITO D. MADROÑAL
VICE PRESIDENT FOR ADMIN AND
FINANCE



APPROVED BY:
DR. MA. CASSA A. OCHOTORENA
WMSU-PRESIDENT

SHEET CONTENTS:
AS SHOWN
PREPARED BY:
ENG. KENT

SHEET NO.

WMSU-PPES-
FR-XXX-XX
EFFECTIVE DATE:
XX XXXX XXXX



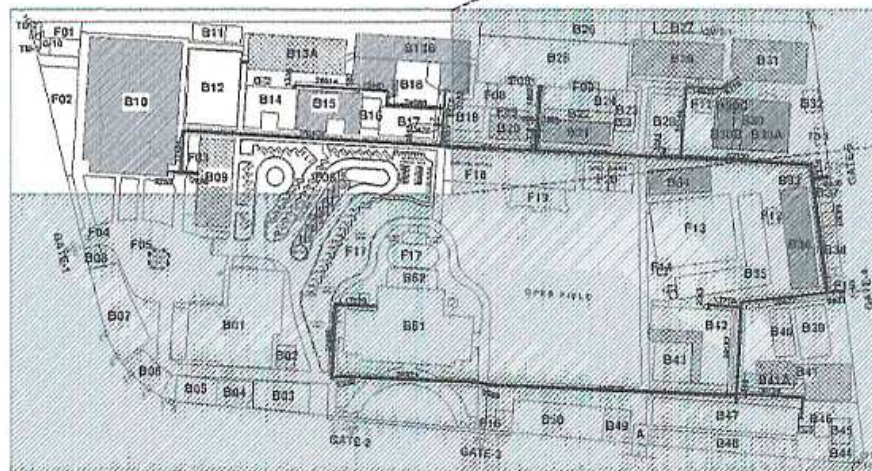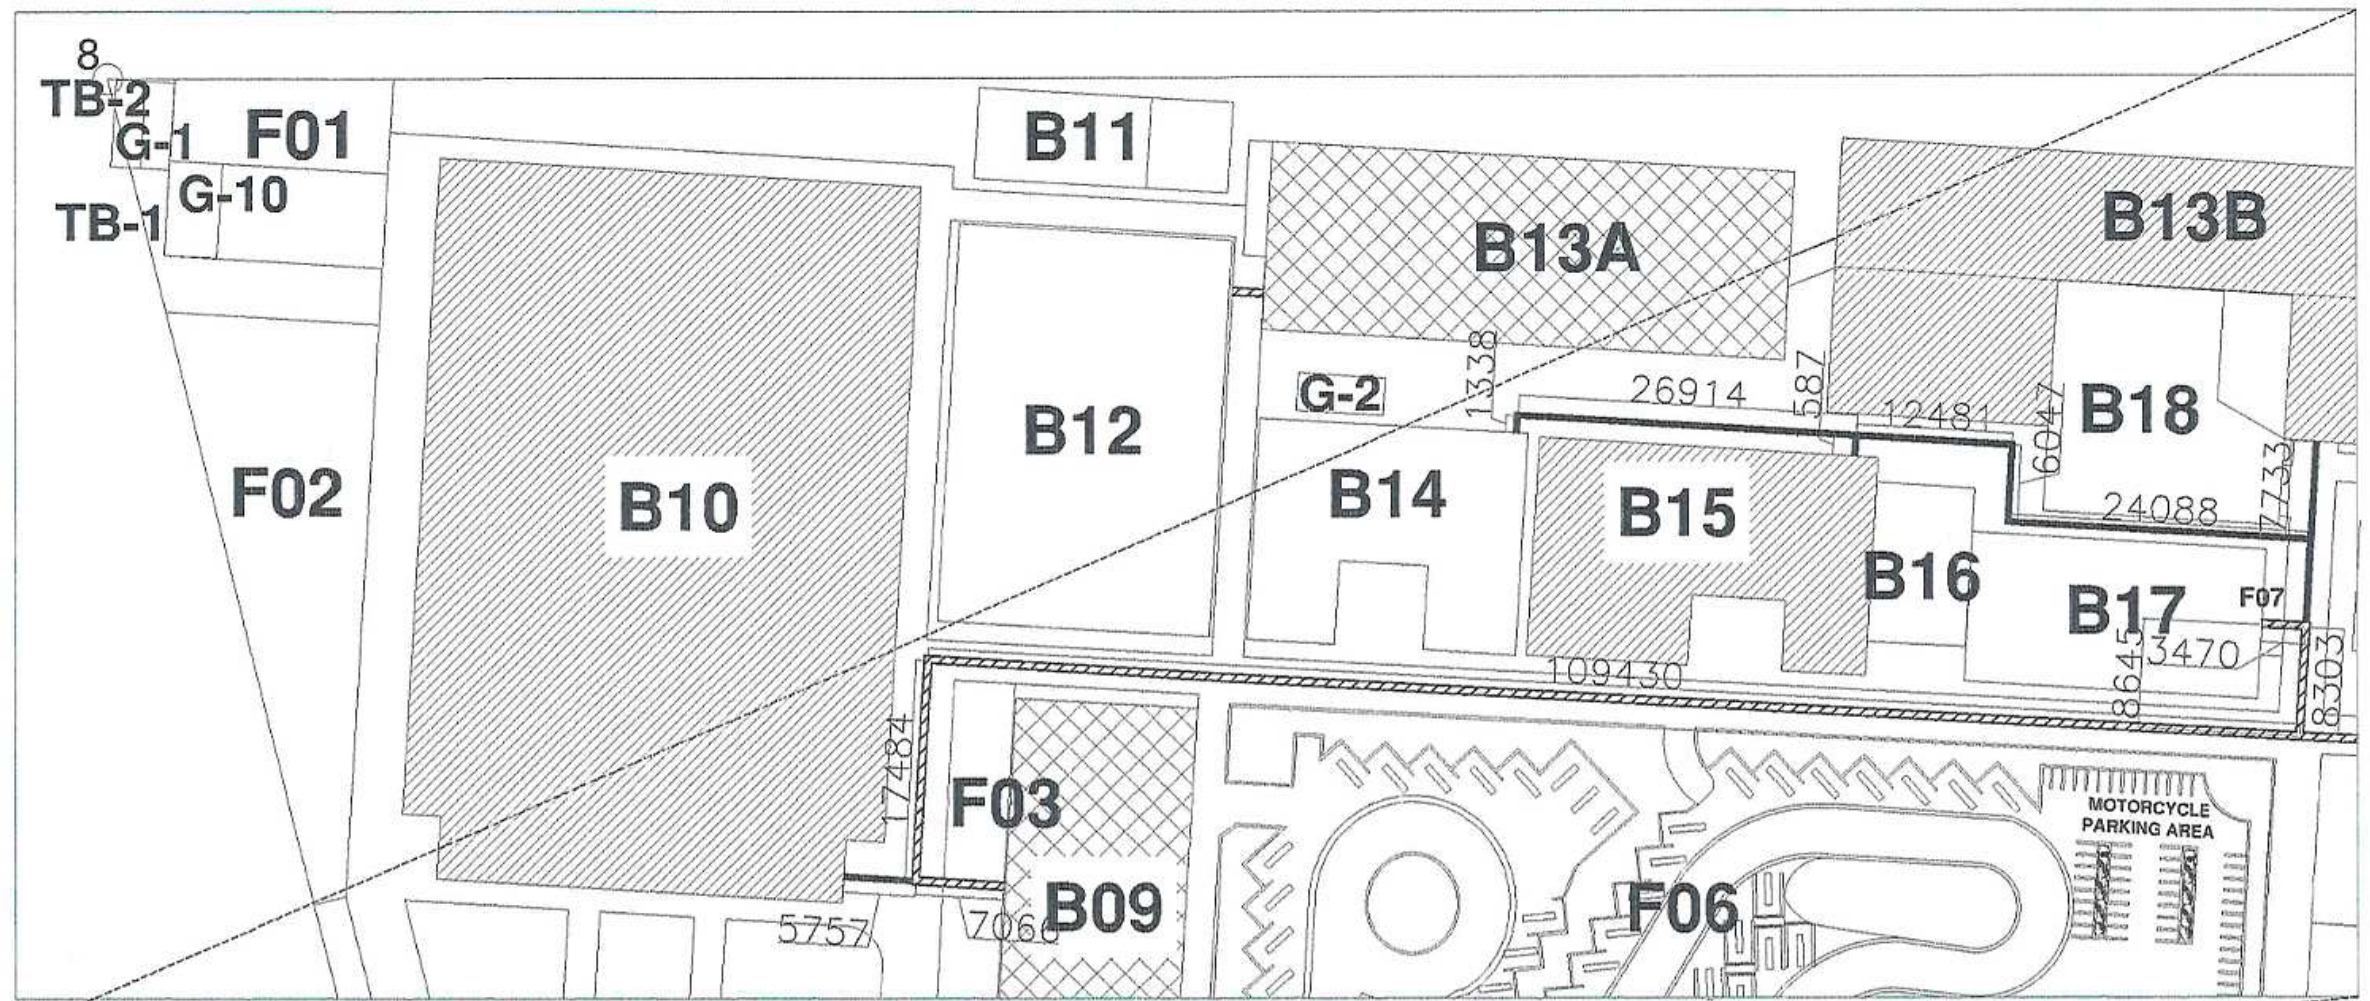

CAMPUS - A ELECTRICAL LAYOUT
SCALE 1:650



DESIGNED BY:
ENGR. RICARDO B. GONZALES
UNIVERSITY ELECTRICAL ENGINEER

PROJECT TITLE:
**ADAPTION OF DIGITAL LEARNING
PLATFORM THROUGH ICT MODERNIZATION**

REQUISITIONER:
ENGR. FERDINAND S. GUARDIA

RECOMMENDING APPROVAL:
ARCH. JOSEPH ANDREW L. SAHIAL, UAP
DIRECTOR OF PHYSICAL PLANT
AND ENGINEERING SERVICES

RECOMMENDING APPROVAL:
DR. JOSELITO D. MADROÑAL
VICE PRESIDENT FOR ADMIN AND
FINANCE

APPROVED BY:
DR. MA. CARLA A. OSOTORENA
WMSU PRESIDENT

SHEET CONTENTS:
AS SHOWN
PREPARED BY:
ENG. KENT


SHEET NO.
1

 
WMSU-PPES-
FR-XXX-XX
EFFECTIVE DATE:
XX XXXX XXXX




PRC: 23724
TIN: 275-203-179
LOCATION: NORMAL ROAD, BALIWASAN, ZAMBOANGA CITY, 7600


PRC: 0010577
PTR: 2929291
TIN: 445-013-228



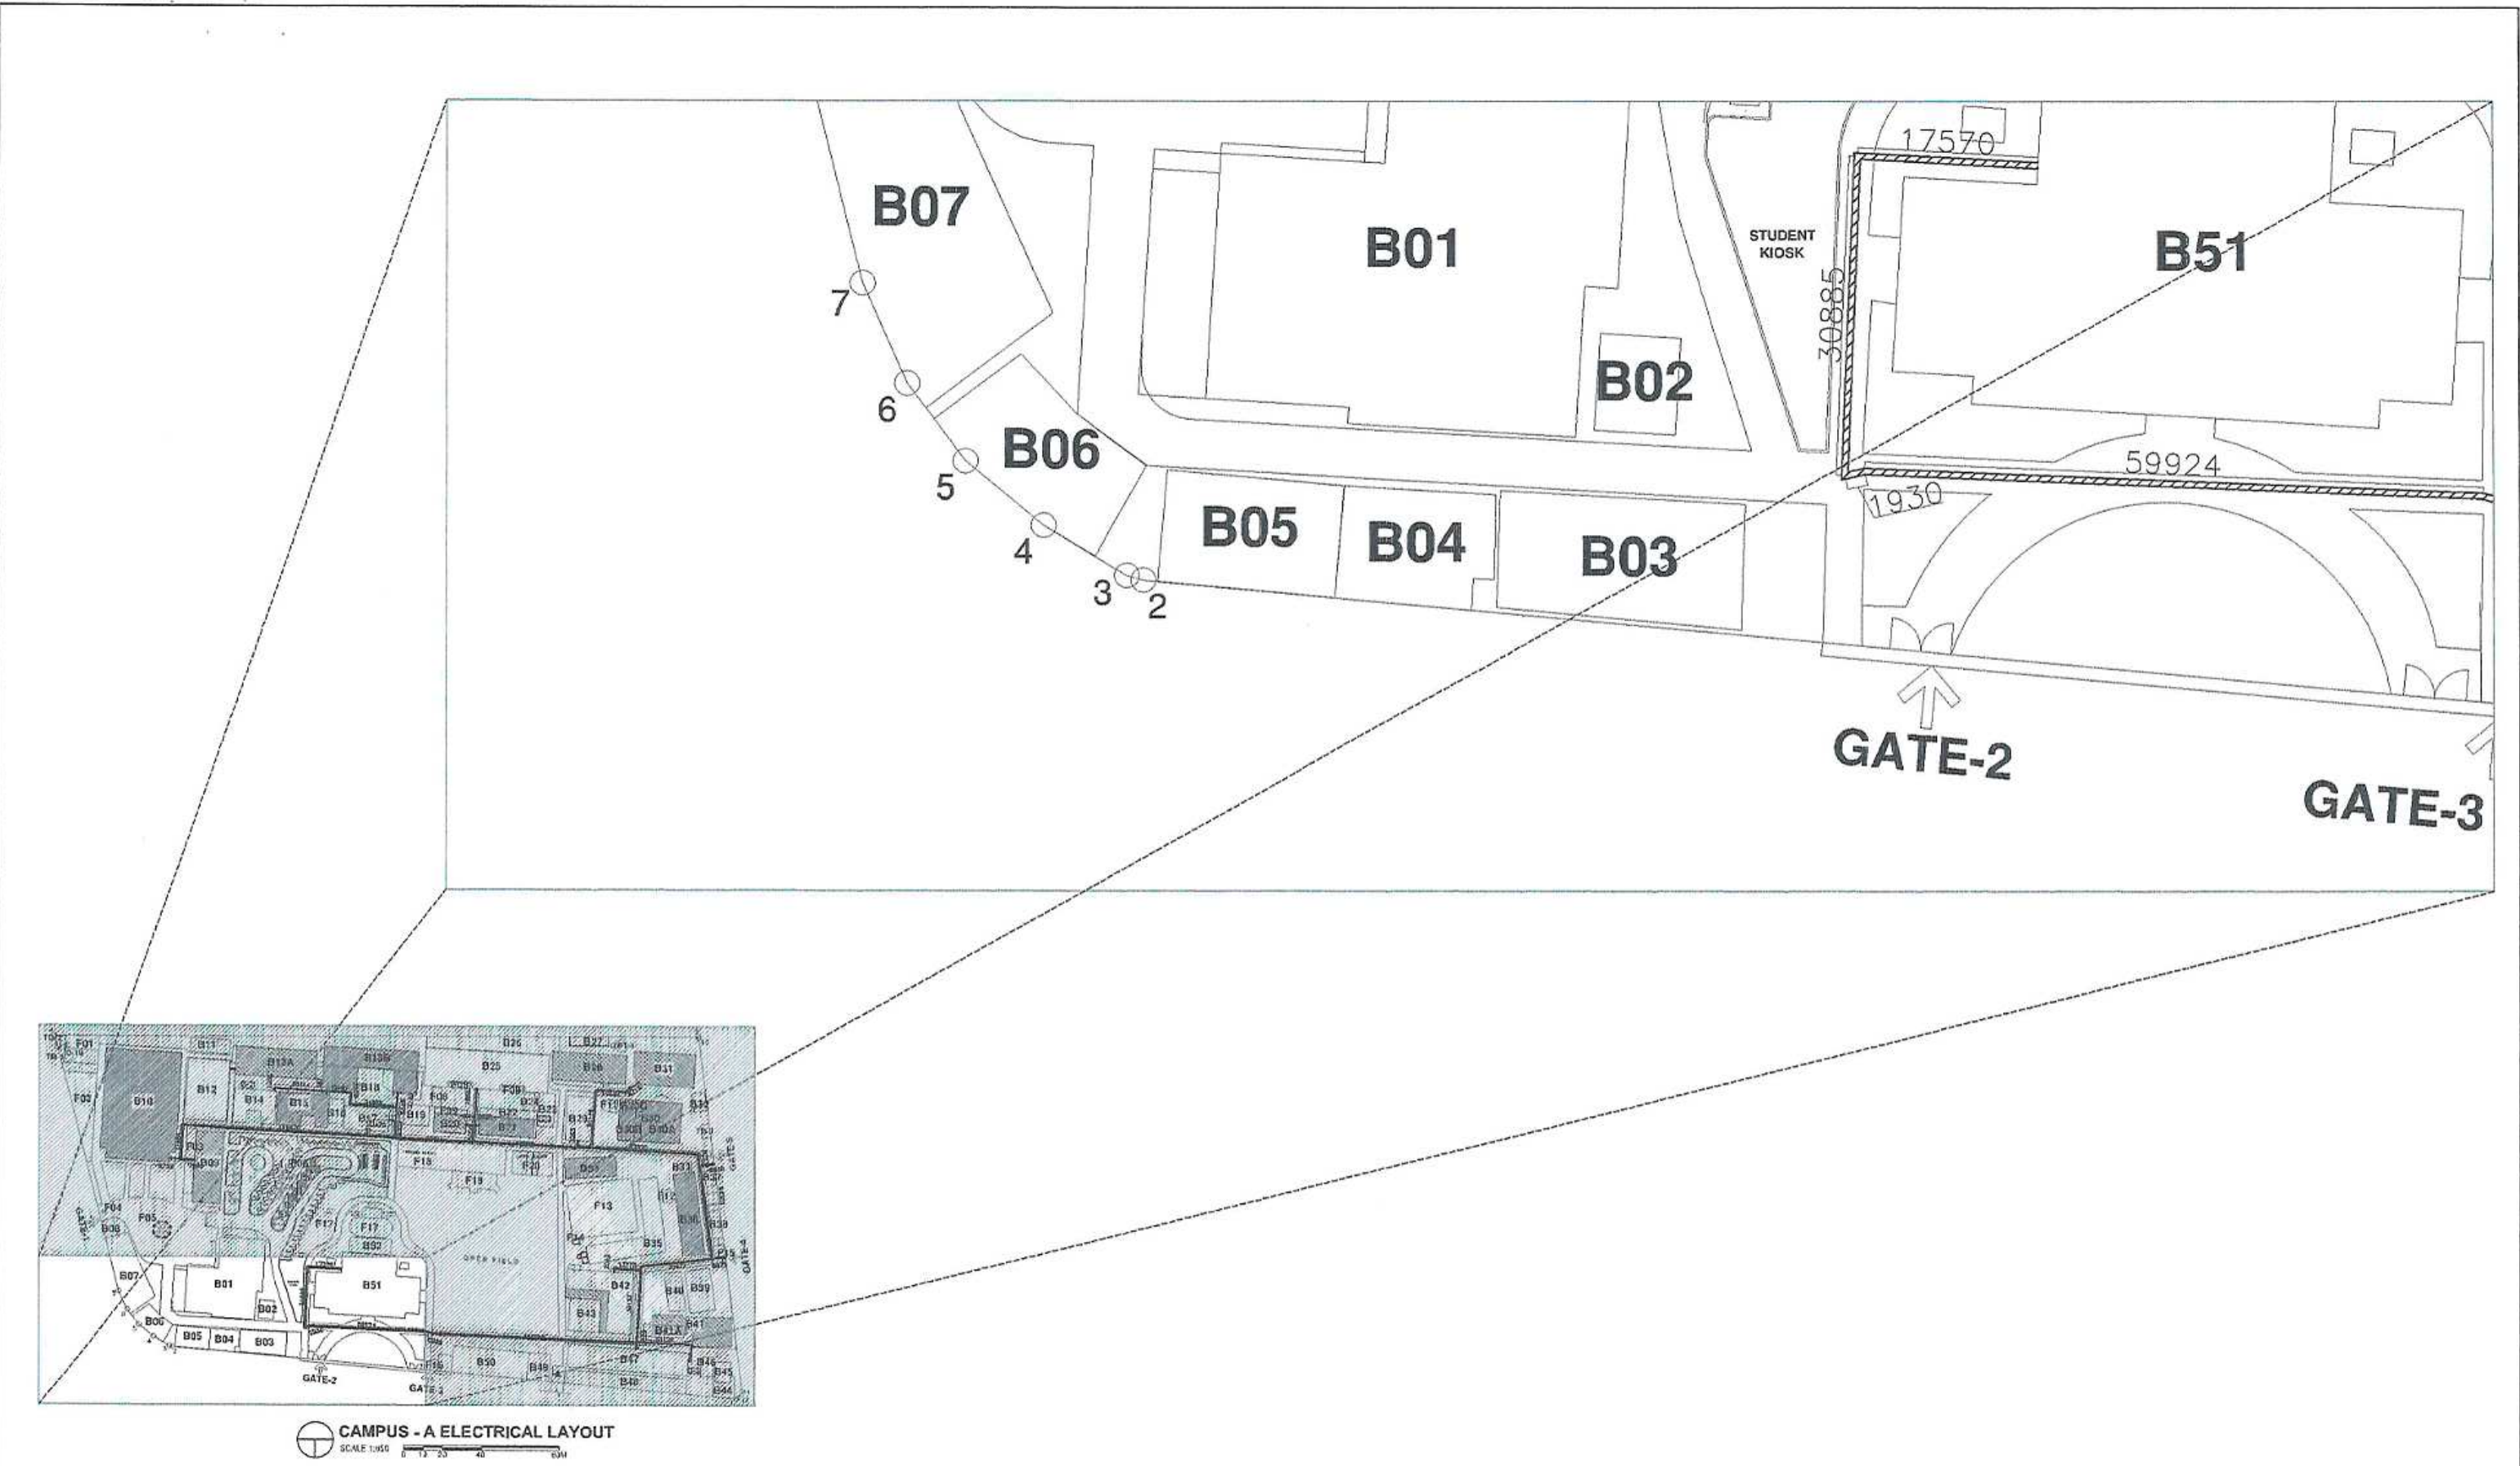



	DESIGNED BY: ENGR. RICARDO B. GONZALES UNIVERSITY ELECTRICAL ENGINEER PRC: 23724 TIN: 275-203-179	PROJECT TITLE: ADAPTION OF DIGITAL LEARNING PLATFORM THROUGH ICT MODERNIZATION LOCATION: NCRMAL ROAD, BALIWASAN, ZAMBOANGA CITY, 7000	REQUISITIONER: ENGR. FERDINAND S. CHARRIO	RECOMMENDING APPROVAL: ARCH. JOSEPH ANDREW L. SAHIA, UAP DIRECTOR OF PHYSICAL PLANT AND ENGINEERING SERVICES PRC: 0010577 PTR: 2929291 TIN: 445-013-228	RECOMMENDING APPROVAL: DR. JOSELITO D. MADRONAL VICE PRESIDENT FOR ADMIN AND FINANCE	APPROVED BY: DR. MA. CARLA MOCHOTORENA WMSU PRESIDENT	SHEET CONTENTS: AS SHOWN PREPARED BY: ENG. KENT	SHEET NO. 	WMSU-PPES- FR-XXX-XX EFFECTIVE DATE: XX XXXX XXXX	
--	---	--	--	--	--	---	---	---	--	---

 LOCATION : BESIDE MISTO BUILDING

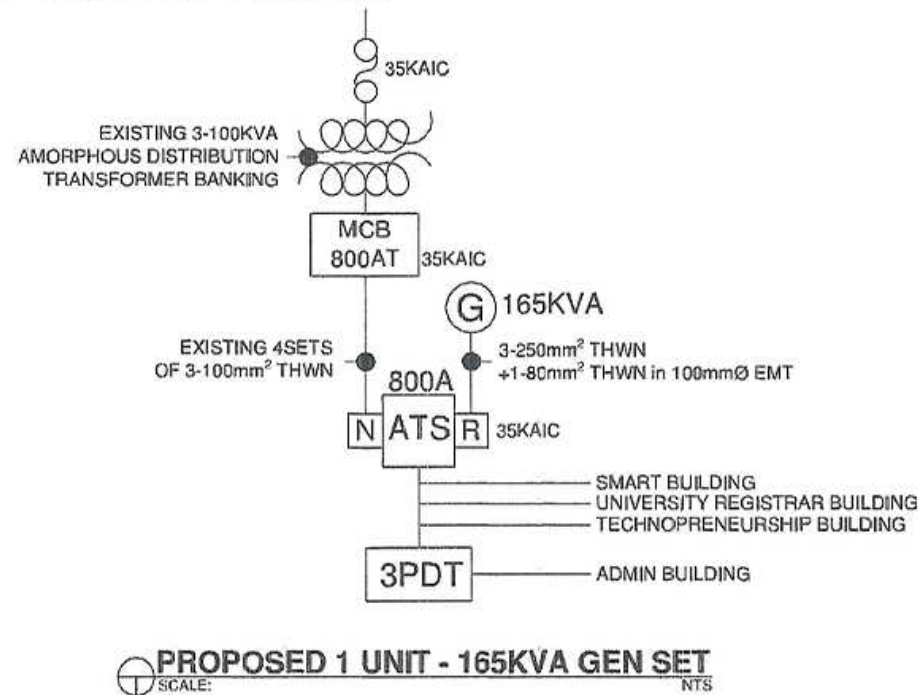

	DESIGNED BY: ENGR. RICARDO B. GONZALES UNIVERSITY ELECTRICAL ENGINEER	PROJECT TITLE: ADAPTION OF DIGITAL LEARNING PLATFORM THROUGH ICT MODERNIZATION	REQUISITIONER ENGR. FERDINAND S. GONZALEZ	RECOMMENDING APPROVAL ARCH. JOSEPH ANDREW L. SAHIAL, UAP DIRECTOR OF PHYSICAL PLANT AND ENGINEERING SERVICES	RECOMMENDING APPROVAL DR. JOSELITO D. MADRONAL VICE PRESIDENT FOR ADMIN AND FINANCE	APPROVED BY: DR. MA. CARLA A. DUCHOTORENA WMSU PRESIDENT	SHEET CONTENTS AS SHOWN PREPARED BY: ENG. KENT	SHEET NO. 	WMSU-PPES-FR-XXX-XX EFFECTIVE DATE: XX XXXX XXXX	
	PRC: 23724 TIN: 275-203-178	LOCATION: NORMAL ROAD, BALIWASAN, ZAMBOANGA CITY, 7000		PRC: 0010577 PTR: 2929291 TIN: 445-013-228						

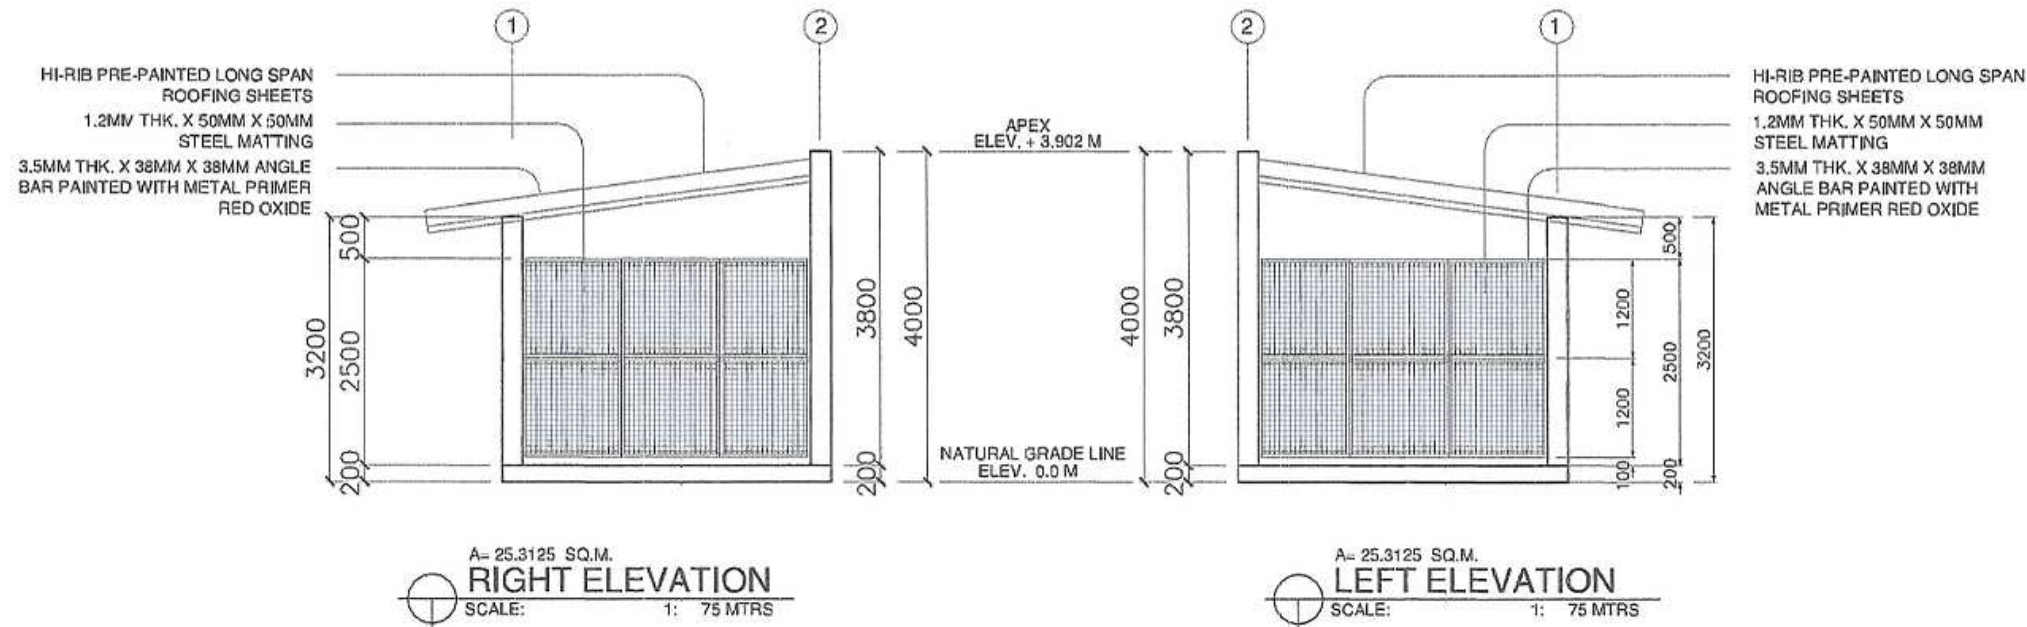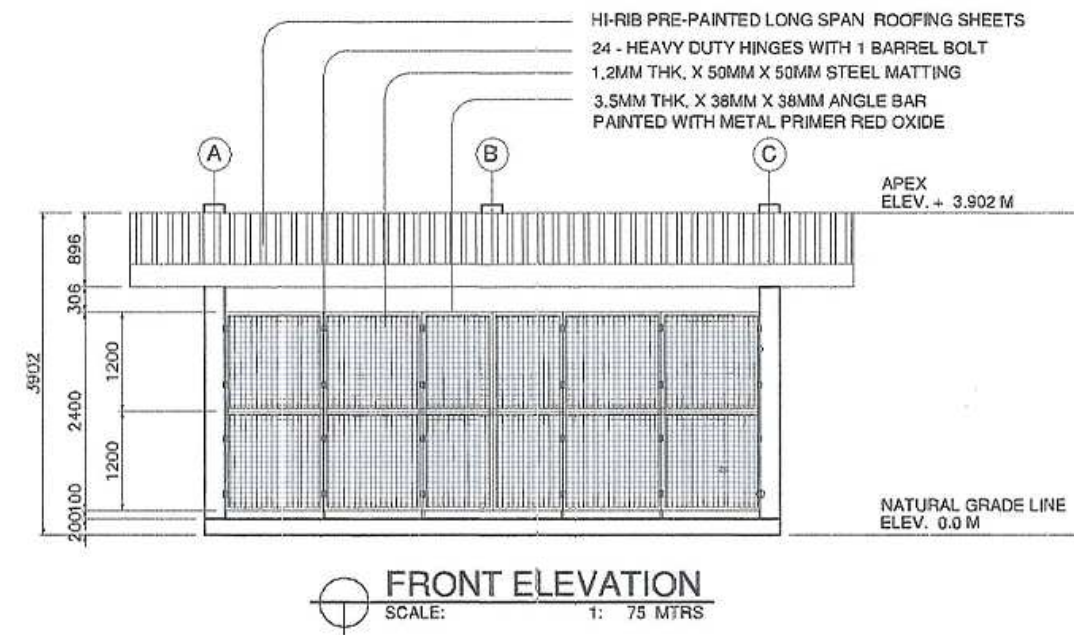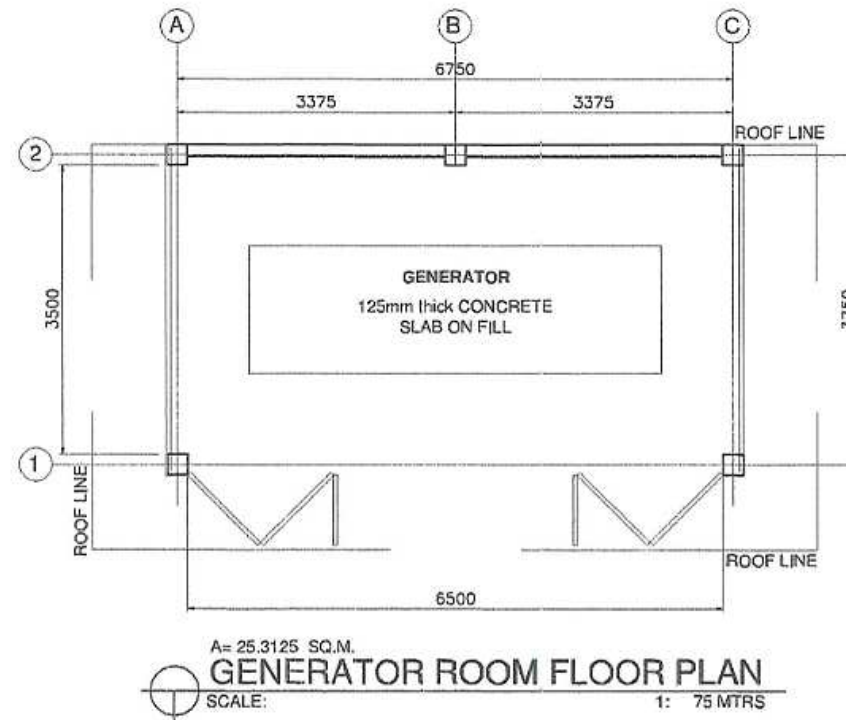

 	DESIGNED BY: ENGR. RICARDO B. GONZALES UNIVERSITY ELECTRICAL ENGINEER PRC: 23724	PROJECT TITLE: ADAPTION OF DIGITAL LEARNING PLATFORM THROUGH ICT MODERNIZATION LOCATION: NORMAL ROAD, BALIWASAN, ZAMBOANGA CITY, 7000	REQUISITIONER: ENGR. FERDINAND S. GUARDO	RECOMMENDING APPROVAL: ARCH. JOSEPH ANDREW L. SAHIAH, UAP DIRECTOR OF PHYSICAL PLANT AND ENGINEERING SERVICES PRC: 0010577 PTR: 2929291 TIN: 445-013-228	RECOMMENDING APPROVAL: DR. JOSELITO D. MADROÑAL VICE PRESIDENT FOR ADMIN AND FINANCE	APPROVED BY: DR. MA. CARLA A. OCHOTORENA WMSU-PRESIDENT	SHEET CONTENTS: AS SHOWN PREPARED BY: ENG. KENT	SHEET NO.:  EFFECTIVE DATE: XX XXXX XXXX	WMSU-PPES-FR-XXX-XX 
--	--	--	--	--	---	--	--	---	--